


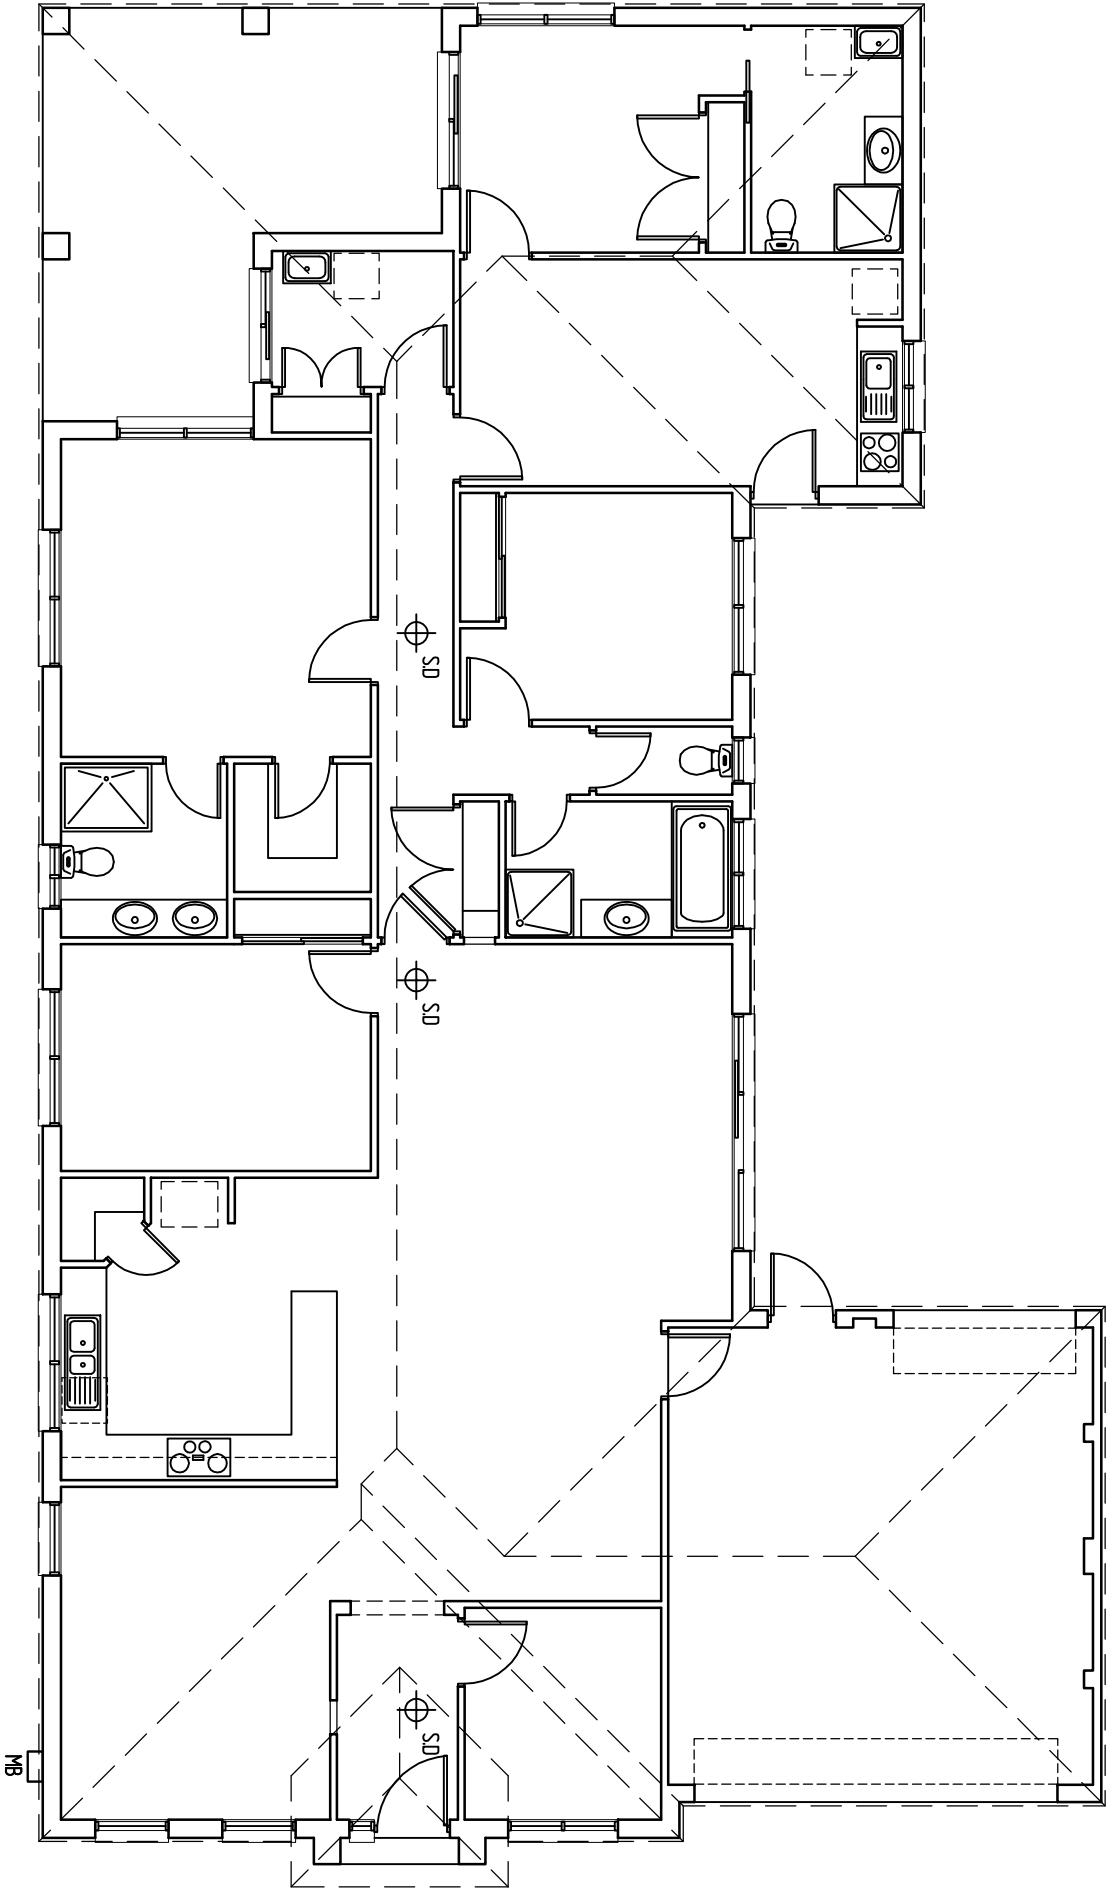

ELECTRICAL LEGEND	
	SINGLE POWER POINT 300H
	SINGLE POWER POINT 1100H
	DOUBLE POWER POINT 300H
	DOUBLE POWER POINT 1100H
	EXTERNAL WEATHERPROOF POWER POINT
	TV COAXIAL POINT
	CEILING MOUNTED BATTEN FITTING
	SMOKE DETECTOR
	DUCTED HEATING OUTLET
	METER BOX & SAFETY SWITCH



14 Clarend Drive
NARE WAREEN 3805 E-MAIL : vandamme@netspace.net.au

PH. 8794 8544 FAX. 8794 8545
DESIGN

client :

NARENDRA C. BABU

site address :

LOT 1263 STATELY DVE.
CRANBOURNE

drawing title :

ELECTRICAL PLAN

note :

DO NOT SCALE DRAWINGS
WRITTEN DIMENSIONS TAKE PRECEDENCE
CONFIRM ALL LEVELS AND DIMENSIONS ON SITE BEFORE
COMMENCEMENT OF WORKS

drawn :

WWD,LVD

checked :

date :

25-2-10

scale :

1:100

issue :

SK-B

job no. :

09099

sheet :

6

of 7

HOME : 9796 3758 MOBILE : 0418 316 810 & 0418 380 71

SEVENTEENTH JULTEX PTY. LTD.
TRADING AS
P.&J. CONSTRUCTIONS
P.O. BOX 14
HALLAM, 3803