


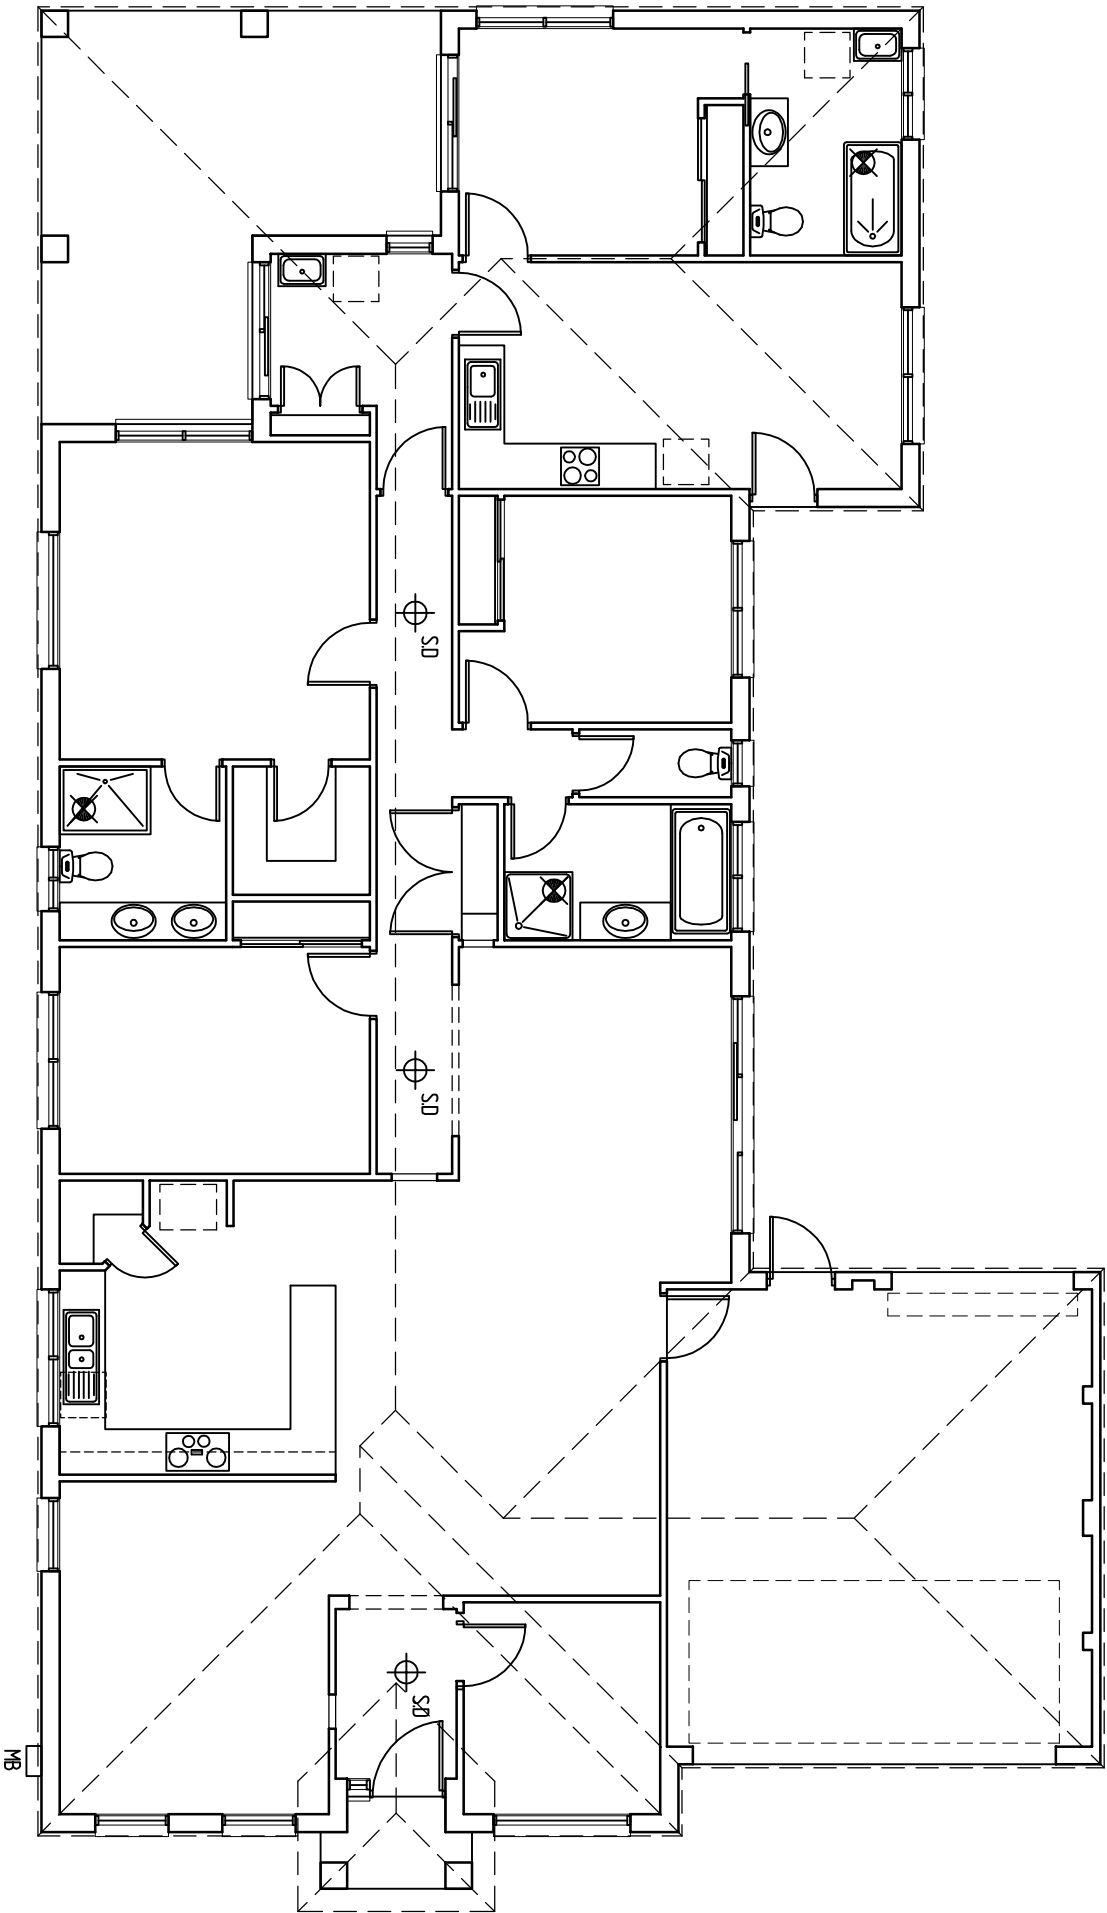

ELECTRICAL LEGEND	
	SINGLE POWER POINT 300H
	SINGLE POWER POINT 1100H
	DOUBLE POWER POINT 300H
	DOUBLE POWER POINT 1100H
	EXTERNAL WEATHERPROOF POWER POINT
	TV COAXIAL POINT
	CEILING MOUNTED BATTEN FITTING
	SMOKE DETECTOR
	DUCTED HEATING OUTLET
	METER BOX & SAFETY SWITCH

SEVENTEENTH JULTEX PTY. LTD.
TRADING AS
P.&J. CONSTRUCTIONS
P.O. BOX 14
HALLAM, 3803

HOME: 9796 3758 MOBILE: 0418 316 810 & 0418 380 781



14 Clarendon Drive
NARE WAREEN 3805
PH. 0794 8544 FAX. 0794 8545
E-MAIL: vandamme@netspace.net.au

client :
NARENDRA C. BABU

site address :
**LOT 1263 STATELY DRIVE
CRANBOURNE**

drawing title :
ELECTRICAL PLAN

note :
DO NOT SCALE DRAWINGS
WRITTEN DIMENSIONS TAKE PRECEDENCE
CONFIRM ALL LEVELS AND DIMENSIONS ON SITE BEFORE
COMMENCEMENT OF WORKS

drawn :
PC

checked :

date :
7-5-10

scale :
1:100

issue :
F

job no. :
09039

sheet :
5

of :
6