
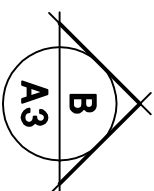
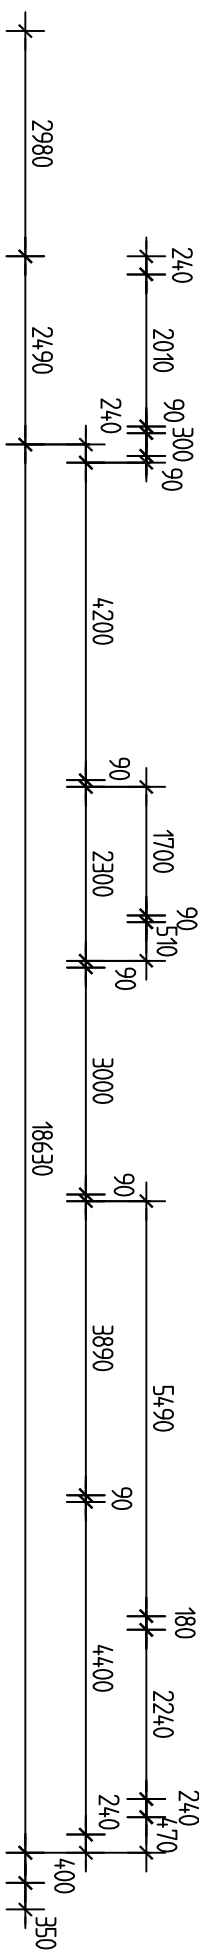
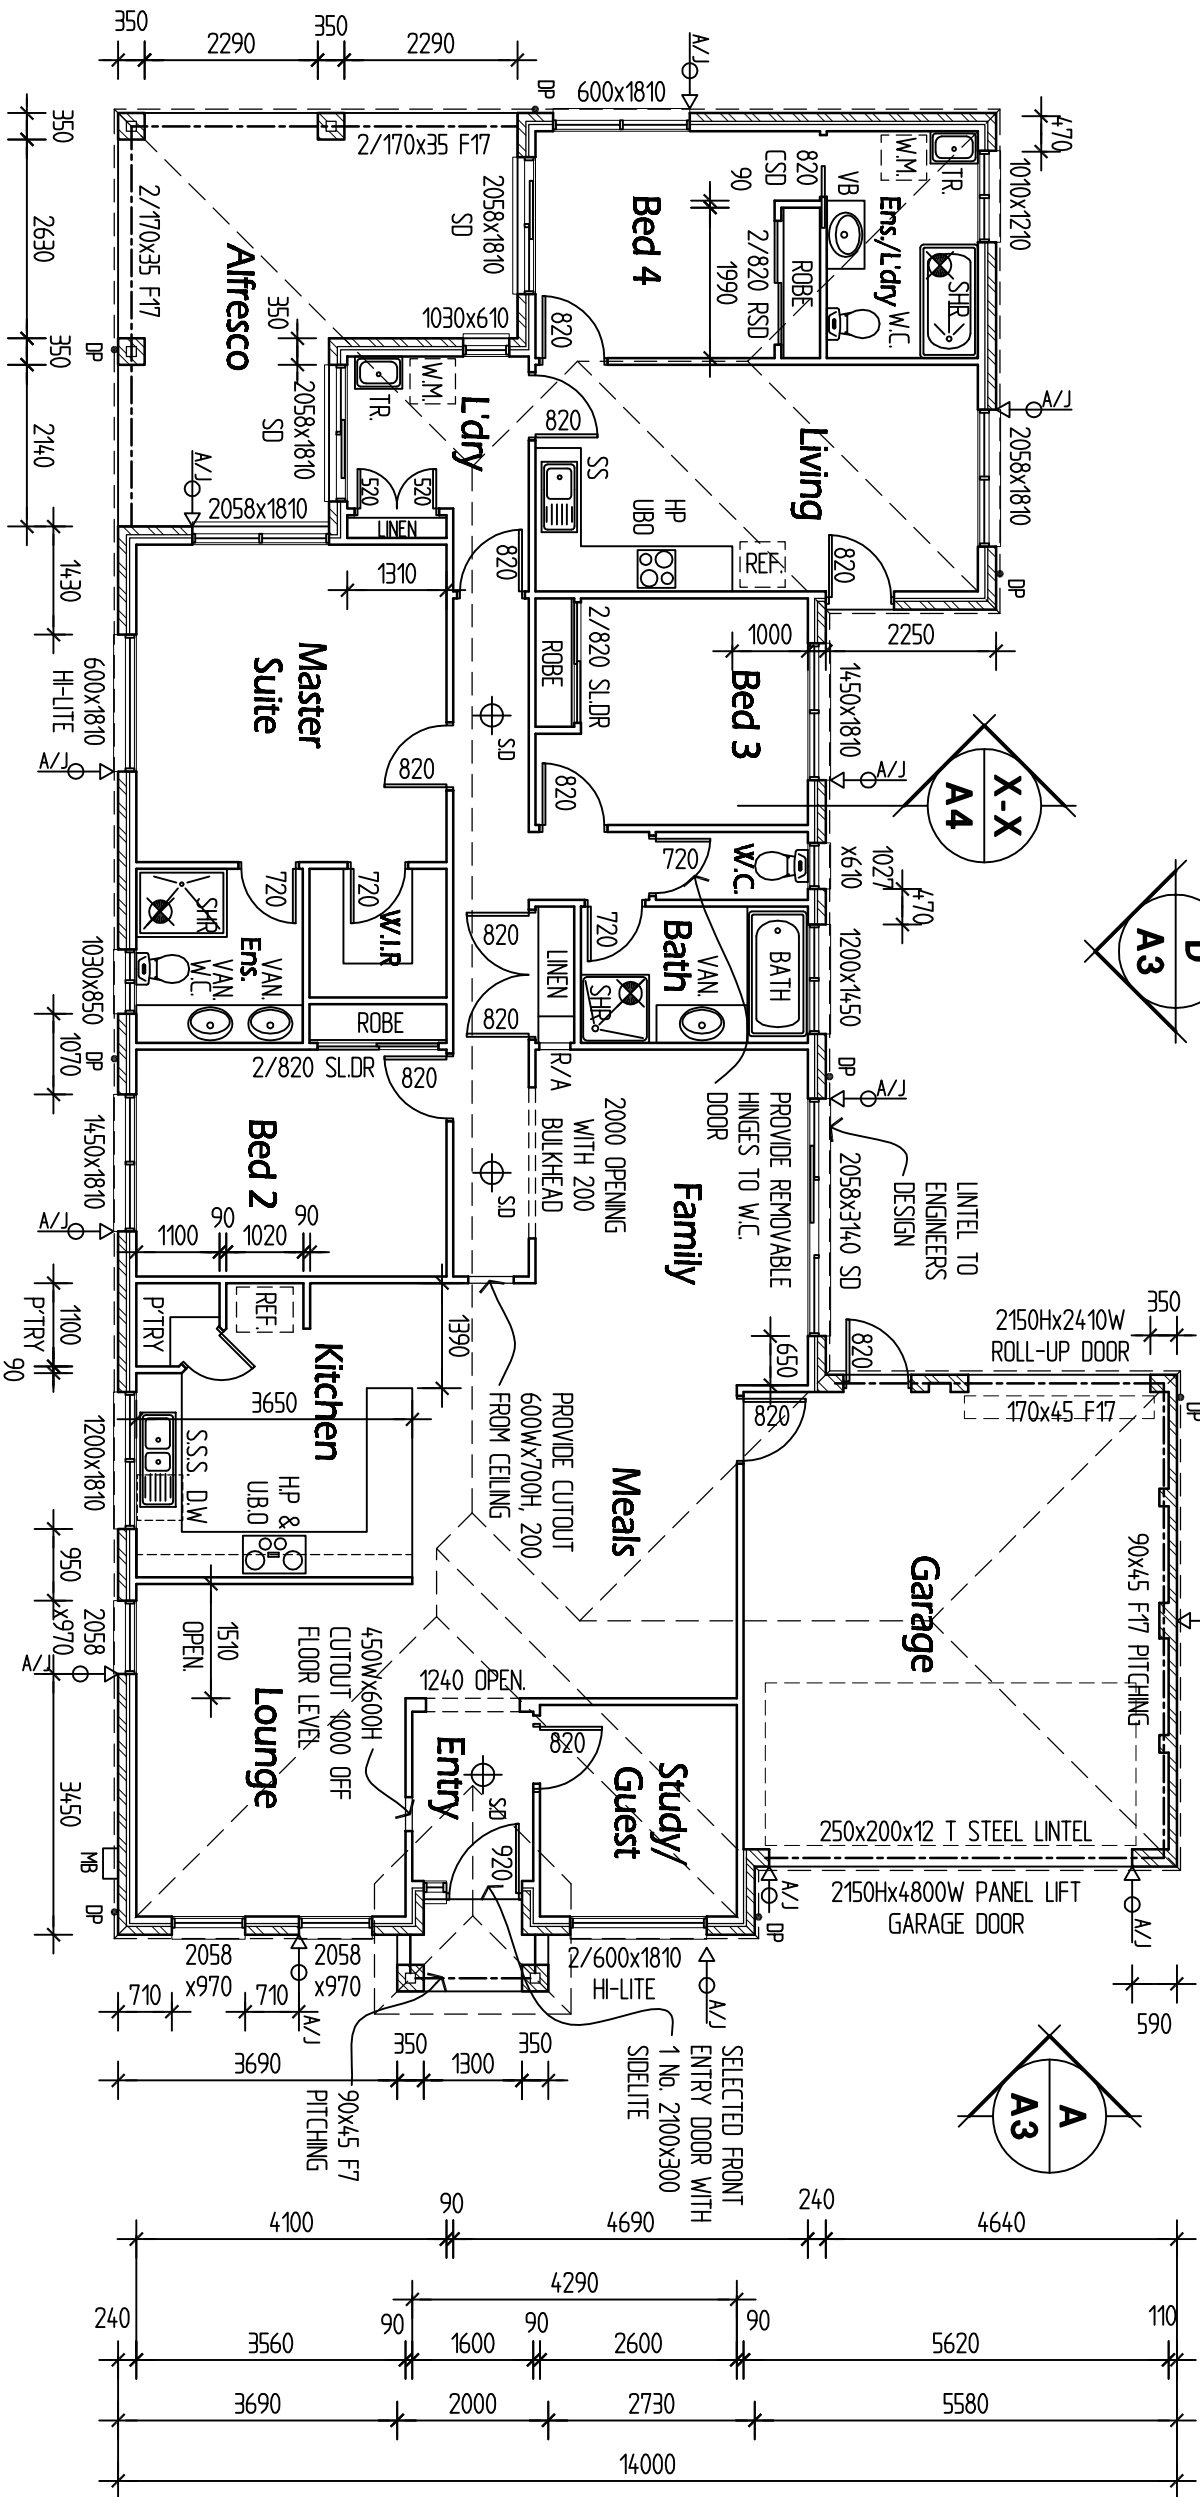
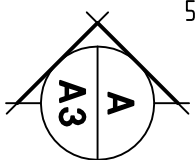
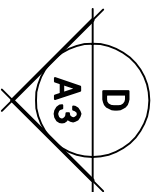
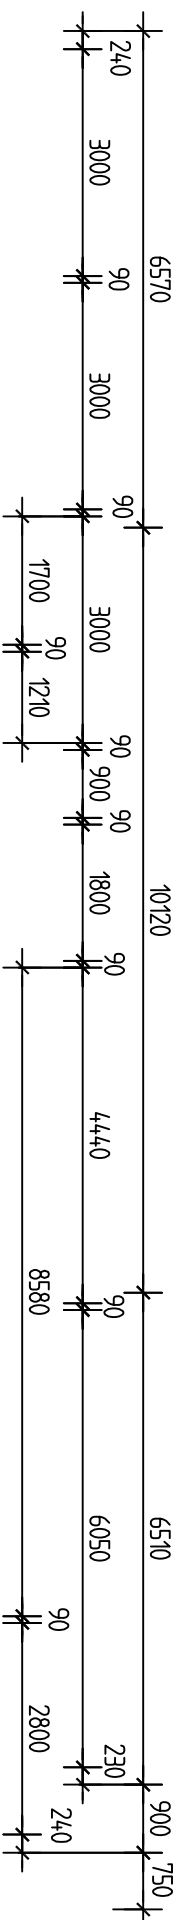
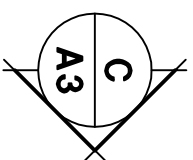


- EXHAUST FAN DUCTED TO EXTERNAL
AR TO PROVIDE 25 LITRE/SECOND
CLEAN AIR
SD
SMOKE DETECTOR IN ACCORDANCE
WITH AS 3786 AND BCA.
PROVIDE BRICKWORK ARTICULATION
JOINT AS REQUIRED

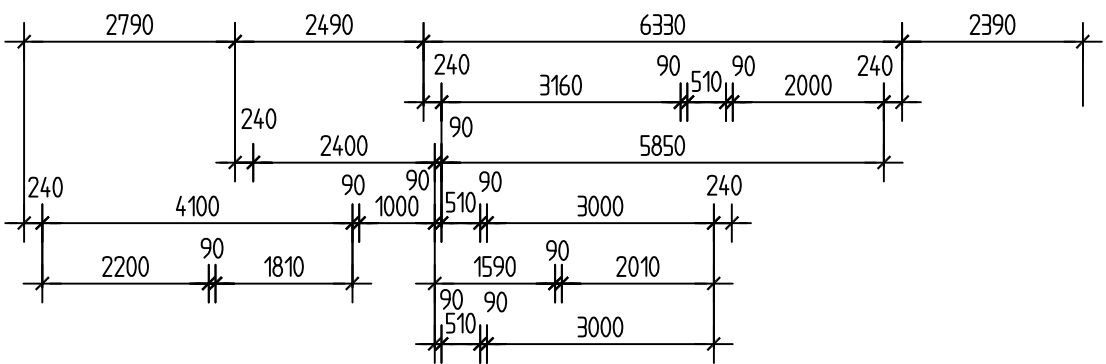

14 Clarendon Drive
NARE WAREEN 3805
PH. 8794 8544
FAX. 8794 8545
E-MAIL: vandamme@nedspace.net.au

client :

NARENDRA C. BABU

site address :

LOT 1263 STATELY DRIVE
CRANBOURNE

drawing title :

FLOOR PLAN

note :

DO NOT SCALE DRAWINGS
WRITTEN DIMENSIONS TAKE PRECEDENCE
CONFIRM ALL LEVELS AND DIMENSIONS ON SITE BEFORE
COMMENCEMENT OF WORKS

drawn :

PC

checked :

date :

7-5-10

scale :

1:100

issue :

F

job no. :

09099

sheet :

2 of 6

HOME: 9796 3758 MOBILE: 0418 316 810 & 0418 380 781

SEVENTEENTH JULTEX PTY. LTD.
TRADING AS
P.&J. CONSTRUCTIONS
P.O. BOX 14
HALLAM, 3803

file : 09099-WK-c by : PC