


- EXHAUST FAN DUCTED TO EXTERNAL AIR TO PROVIDE 25 LITRES/SECOND CLEAN AIR
- SD
- SPRINK DETECTOR IN KITCHEN WITH AS 3706 AND BEA
- PROVIDE BECKHOFF ATTENUATION UNIT AS REQUIRED

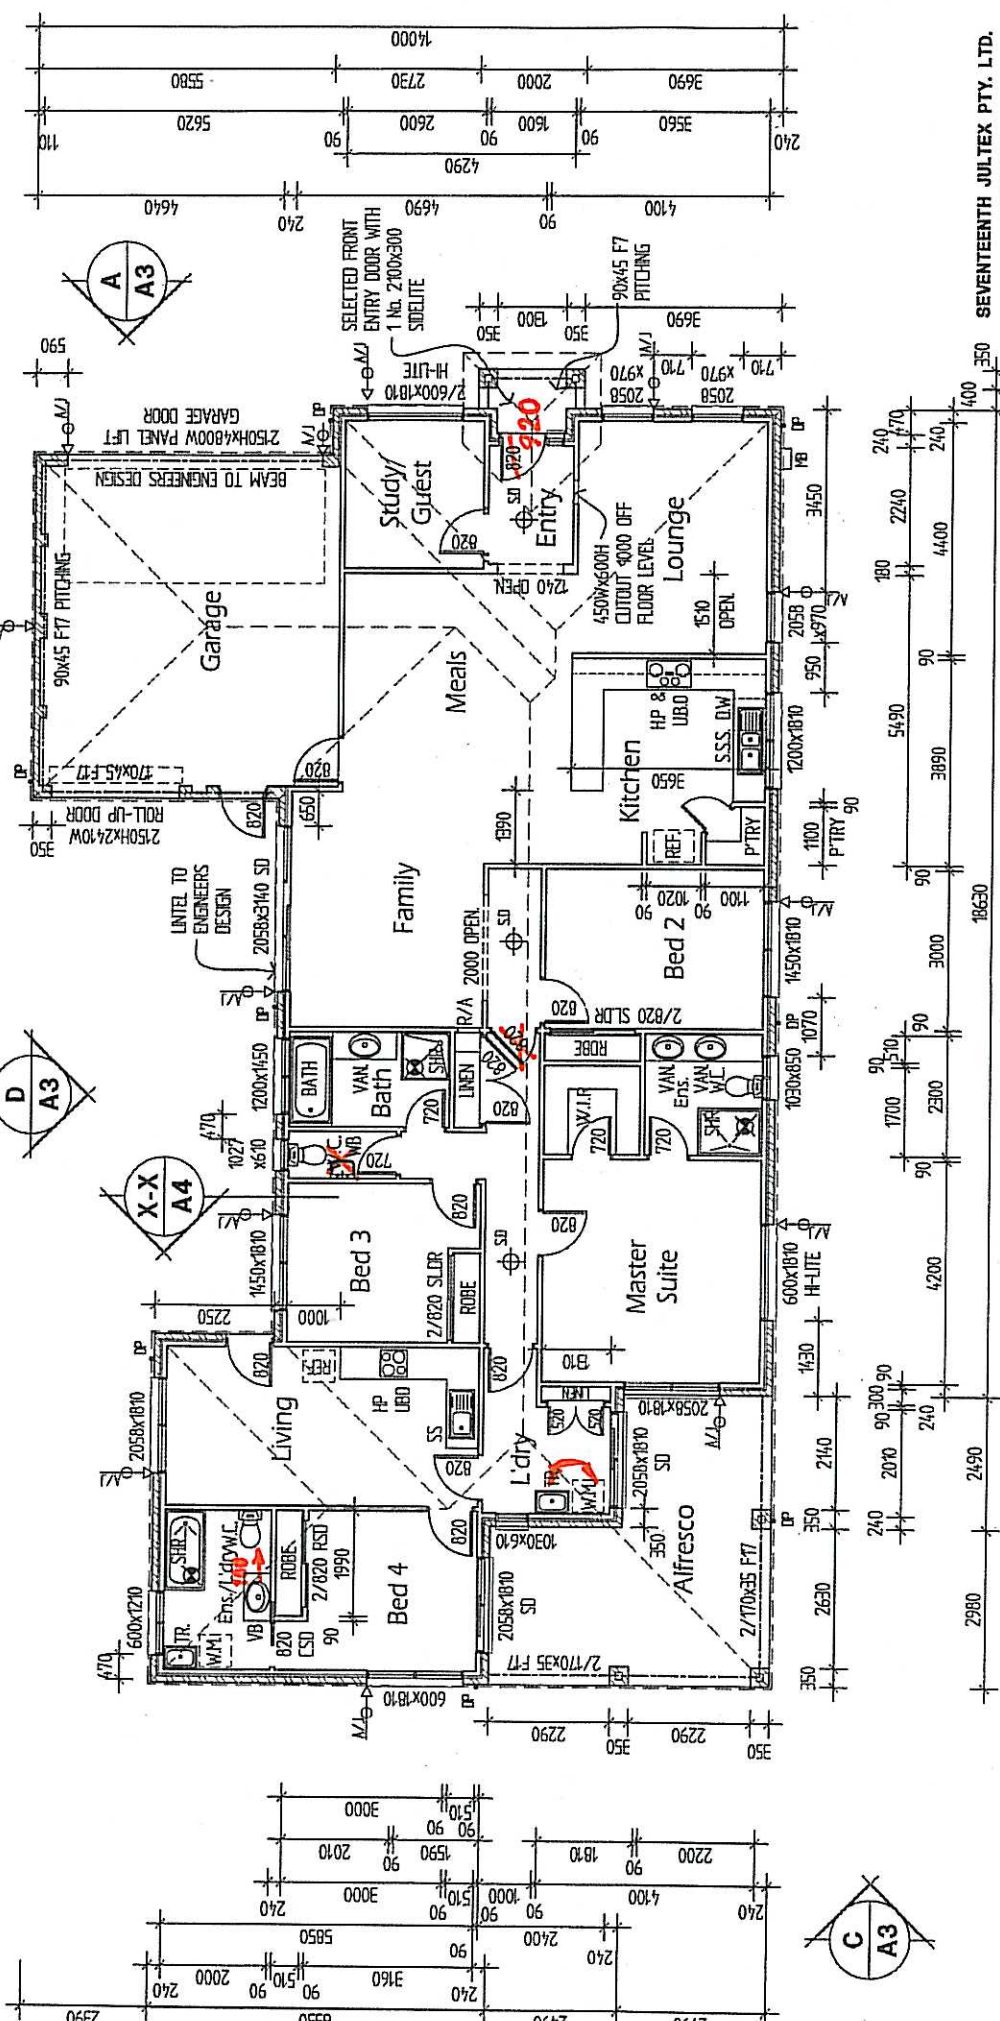

SEVENTEENTH JULTEX PTY. LTD.
TRADING AS
P.&J. CONSTRUCTIONS
P.O. BOX 14
HALLAM, 3803

HCM-E-9796-3758 MOBILE: 0418 316 810 & 0418 360 781

drawn:	PC	checked:	
date:	22-4-10	scale:	1:100
job no.:	10003	sheet:	2 of 5

drawing title:	FLOOR PLAN
note:	DO NOT SCALE DRAWINGS WRITTEN DIMENSIONS TAKE PRECEDENCE CONFIRM ALL LEVELS AND DIMENSIONS ON SITE BEFORE CONSTRUCTION COMMENCEMENT

client:	NARENDRA C. BABU
site address:	LOT 1263 STately DRIVE CRANBOURNE